



**PLANT SCHEDULE**

PLANT	QTY	SIZE	SYMBOL	COMMON NAME	SCIENTIFIC NAME	PLANT	QTY	SIZE	SYMBOL	COMMON NAME	SCIENTIFIC NAME
<b>NEW TREES</b>						<b>SUCCULENTS AND CACTI</b>					
	1	36" BOX		BLUE PALO VERDE	Cercidium floridum		30	5 gal		DESERT MILKWEED	Asclepias subulata
	2	36" BOX		NATIVE MEQUITE	Prosopis juliflora		30	5 gal		LADY SLIPPER	Euphorbia macrocarpus
	2	36" BOX		IRONWOOD	Lomega tesota		5	4 gal		SAGUARO	Carregia gigantea
	2	36" BOX		SWEET ACACIA	Chilopsis limeris		20	5 gal		FEROCACTUS	
	5	36" BOX		TEXAS MOUNTAIN LAUREL	Sophora secundiflora		40	5 gal		ALOE BLUE ELF	
	4	36" BOX		DESERT WILLOW	Acacia smallii		15	5 gal		HEDGEHOG CACTUS	Echinocereus engelmannii
<b>SHRUBS</b>						<b>WILDFLOWERS / GROUND COVER</b>					
	20	5 gal		BRITTLEBUSH	Encelia farinosa		40	1 gal		DESERT MARIGOLD	Baileya multirallata
	15	5 gal		CHUPAROSA	Justicia californica		40	1 gal		PURPLE HEART	Tradescantia pallida
	20	15 gal		CREOSOTE	Larrea tridentata	<b>EXISTING TREES</b>					
	30	5 gal		AUTUMN SAGE	Salvia greggii					EXISTING DESERT TREE TO REMAIN	
	10	5 gal		LITTLE LEAF CORDIA	Cordia parvifolia	<b>LAWN</b>					
	10	15 gal		MEXICAN YELLOW BIRD	Caesalpinia mexicana					ARTIFICIAL TURF	
	40	5 gal		DWARF BOTTLEBRUSH	Callistemon citrinus	<b>BOULDERS</b>					
										EXISTING SAGUARO	

**TENNEN STUDIO**  
 4702 EAST INDIAN SCHOOL ROAD PHOENIX, ARIZONA 85018  
 PHONE 602.840.8625 FAX 602.840.8632  
 WWW.TENNENSTUDIO.COM

**LEGEND**

- PROPOSED AREA OF DISTURBANCE
- PREVIOUS AREA OF DISTURBANCE
- AREA TO BE RESTORED TO HISTORIC TERRAIN AND REVEGETATED
- BUILDING FOOTPRINT

EXISTING DRIVEWAY RE-VEGETATION METHOD:  
 • WE WILL USE CHOLLA SALVAGED FROM OTHER DISTURBED AREAS OF SITE.  
 • PROTECT EXISTING TREES AND SAGUAROS.  
 • SUPPLEMENT WITH NEW CREOSOTE, QUAIL BUSH, AND DESERT MARIGOLD WITH TEMPORARY IRRIGATION UNTIL ESTABLISHED.  
 • GROUND COVER SHALL BE SITE SALVAGED, SCATTERED TO ACHIEVE NATURAL DESERT FLOOR.  
 • MANAGE WEEDS AS NEEDED.

**SITE LIGHTING FIXTURE SCHEDULE**

TYPE	QTY.	MANUFACTURER	DESCRIPTION	LUMENS	WATTAGE	COLOR TEMP.	FINISH COLOR
PL	17	FX	SPIPOX 12R-CU-SS 12V MINI PATH LIGHT	100	10 WATT	2700 K	DARK BRONZE
TD	14	LUMIERE	213-BZ 12V DANGLING TREE DOWN LIGHT NOTE: LIGHTING TO BE PLACED NO HIGHER THAN 8' ABOVE GRADE	100	12 WATT	2700 K	DARK BRONZE
GU	35	LUMIERE	201-BZ/GS08 12V GROUND MOUNTED TREE UP LIGHT	100	12 WATT	3000 K	DARK BRONZE

**NEW LOCATIONS FOR SALVAGED TREES, SAGUARO, & FEROCACTUS**

- 1 8" SINGLE SAGUARO
- 2 3' FEROCACTUS
- 3 5' SINGLE SAGUARO
- 4 10' SINGLE SAGUARO
- 5 6' SINGLE SAGUARO
- 6 8" BLUE PALO VERDE
- 7 10" BLUE PALO VERDE
- 8 3' FEROCACTUS
- 9 4' FEROCACTUS
- 10 12" BLUE PALO VERDE

NO. ISSUES/REVISIONS DATE

PROJECT **HBL**

7550 N. HUMMINGBIRD LANE  
PARADISE VALLEY, AZ 85253

DATE 23 OCTOBER 2018

SCALE 1/16"=1'-0"


**LANDSCAPE SITE PLAN**

SHEET

**SPL1.0**


All drawings and written material appearing herein constitute original and unpublished work of the Designer and may not be duplicated, used or disclosed without consent of Designer.



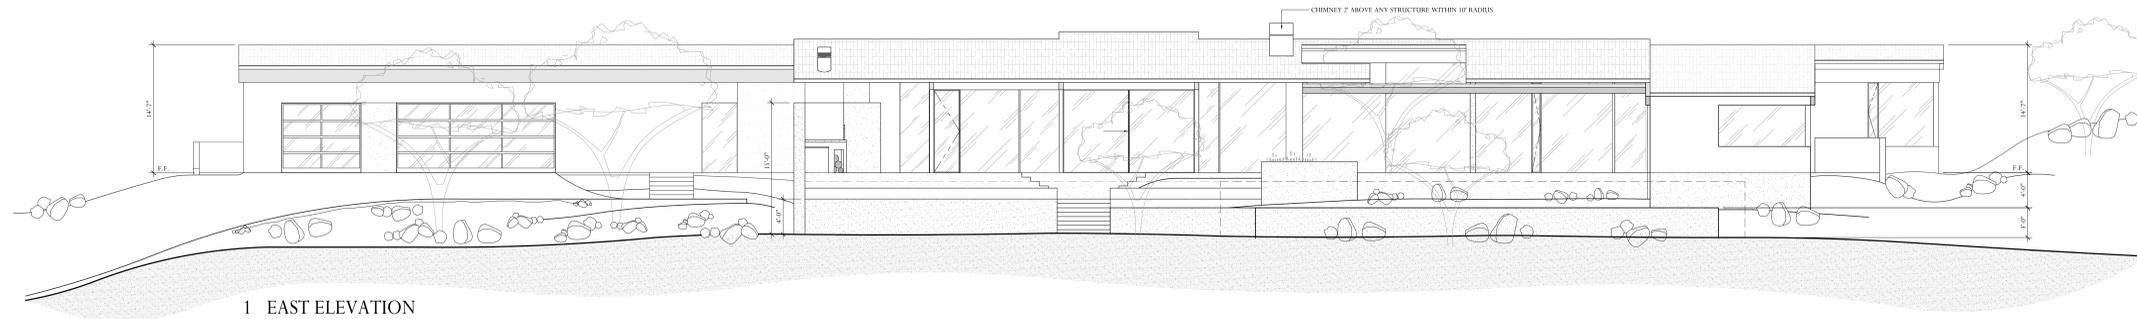


1 EAST ELEVATION

SCALE: 1/8"=1'-0"

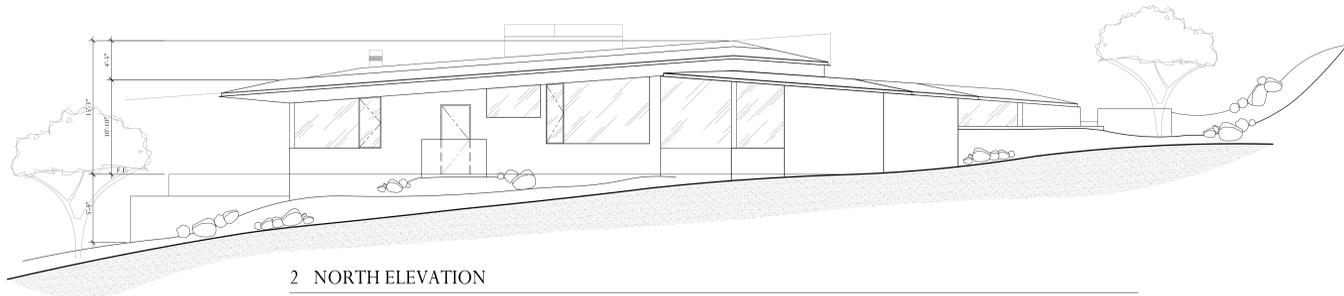


2 NORTH ELEVATION

SCALE: 1/8"=1'-0"

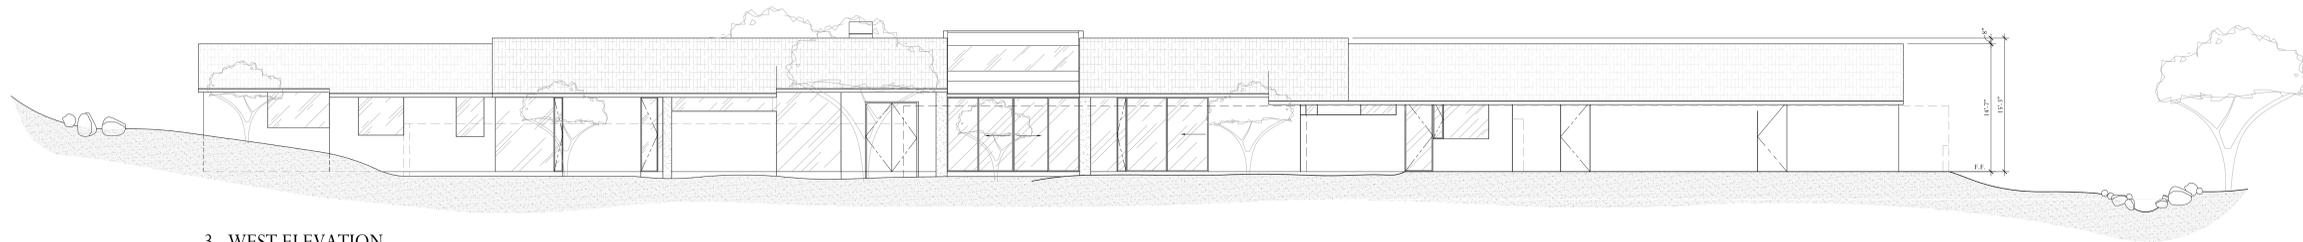

3 WEST ELEVATION

SCALE: 1/8"=1'-0"

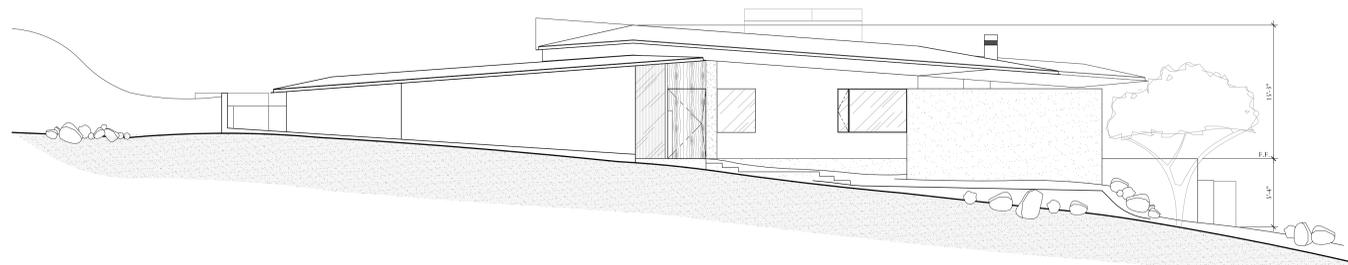

4 SOUTH ELEVATION

SCALE: 1/8"=1'-0"

NO. ISSUES/REVISIONS DATE



PROJECT **HBL**

7550 N. HUMMINGBIRD LANE  
 PARADISE VALLEY, AZ 85253


DATE 23 OCTOBER 2018

SCALE 1/8"=1'-0"

BUILDING ELEVATIONS


SHEET

**B A2.0**

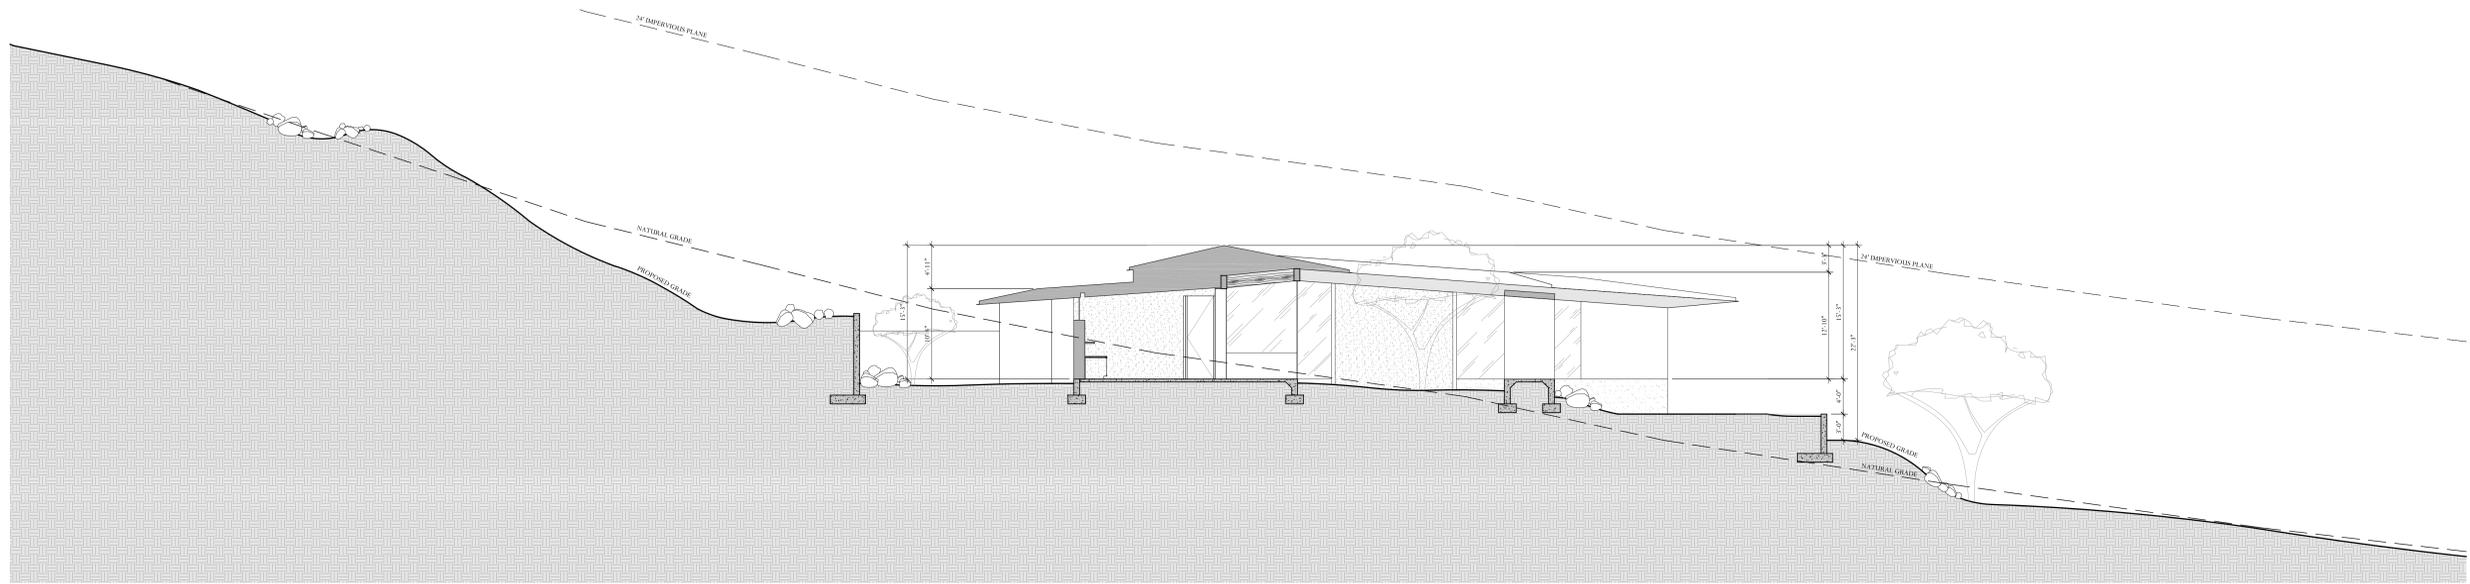


1 SITE SECTION @ BUILDING

SCALE: 1/8"=1'-0"

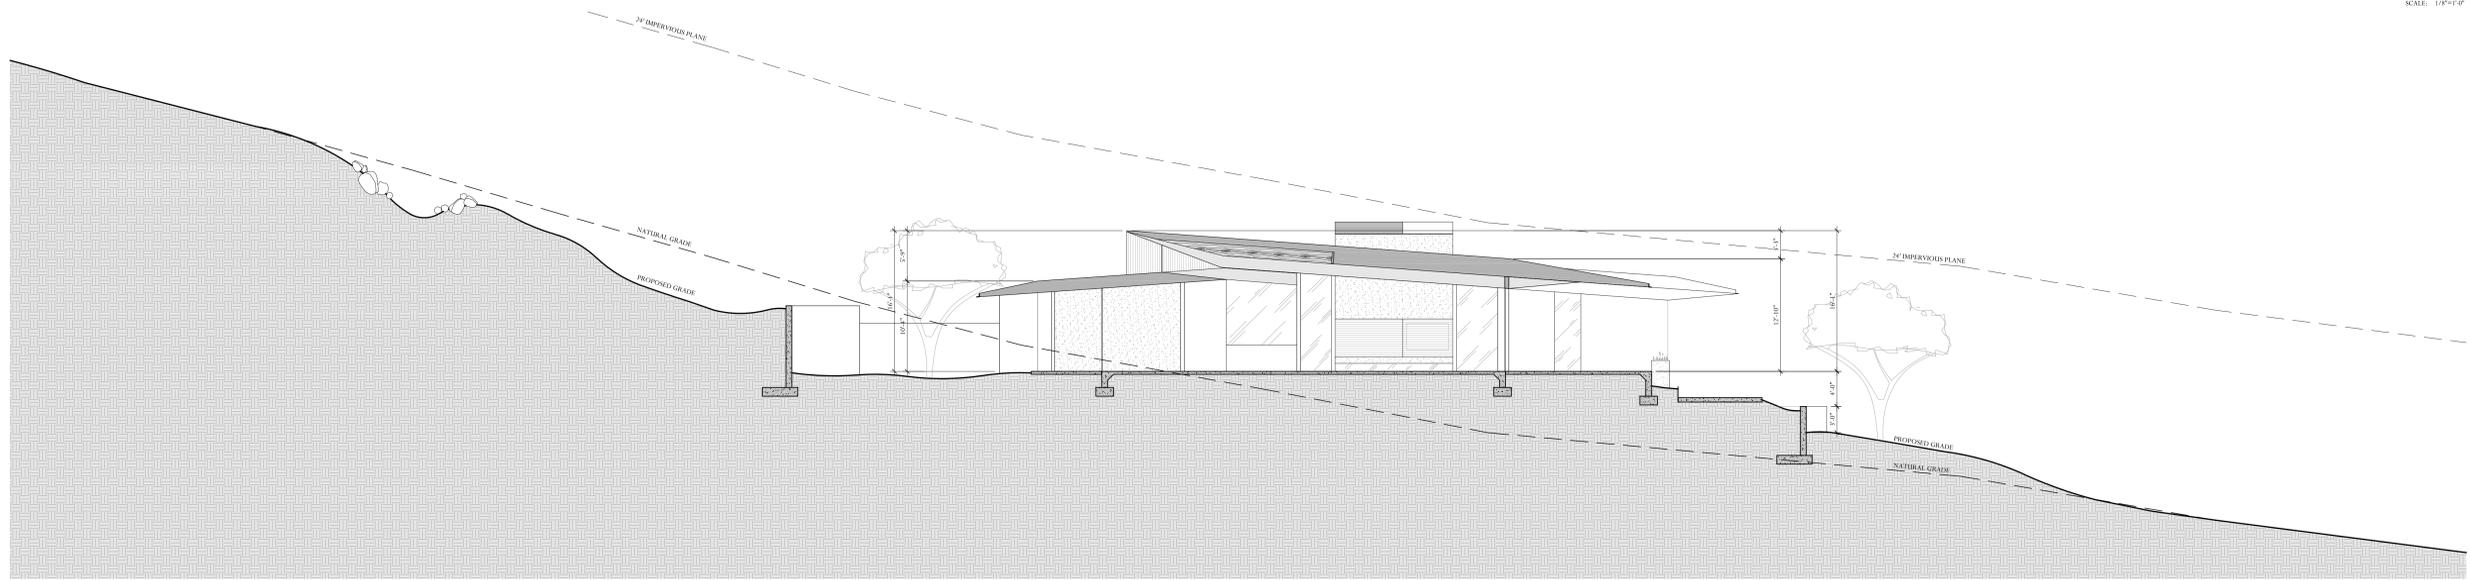

2 SITE SECTION @ BUILDING

SCALE: 1/8"=1'-0"

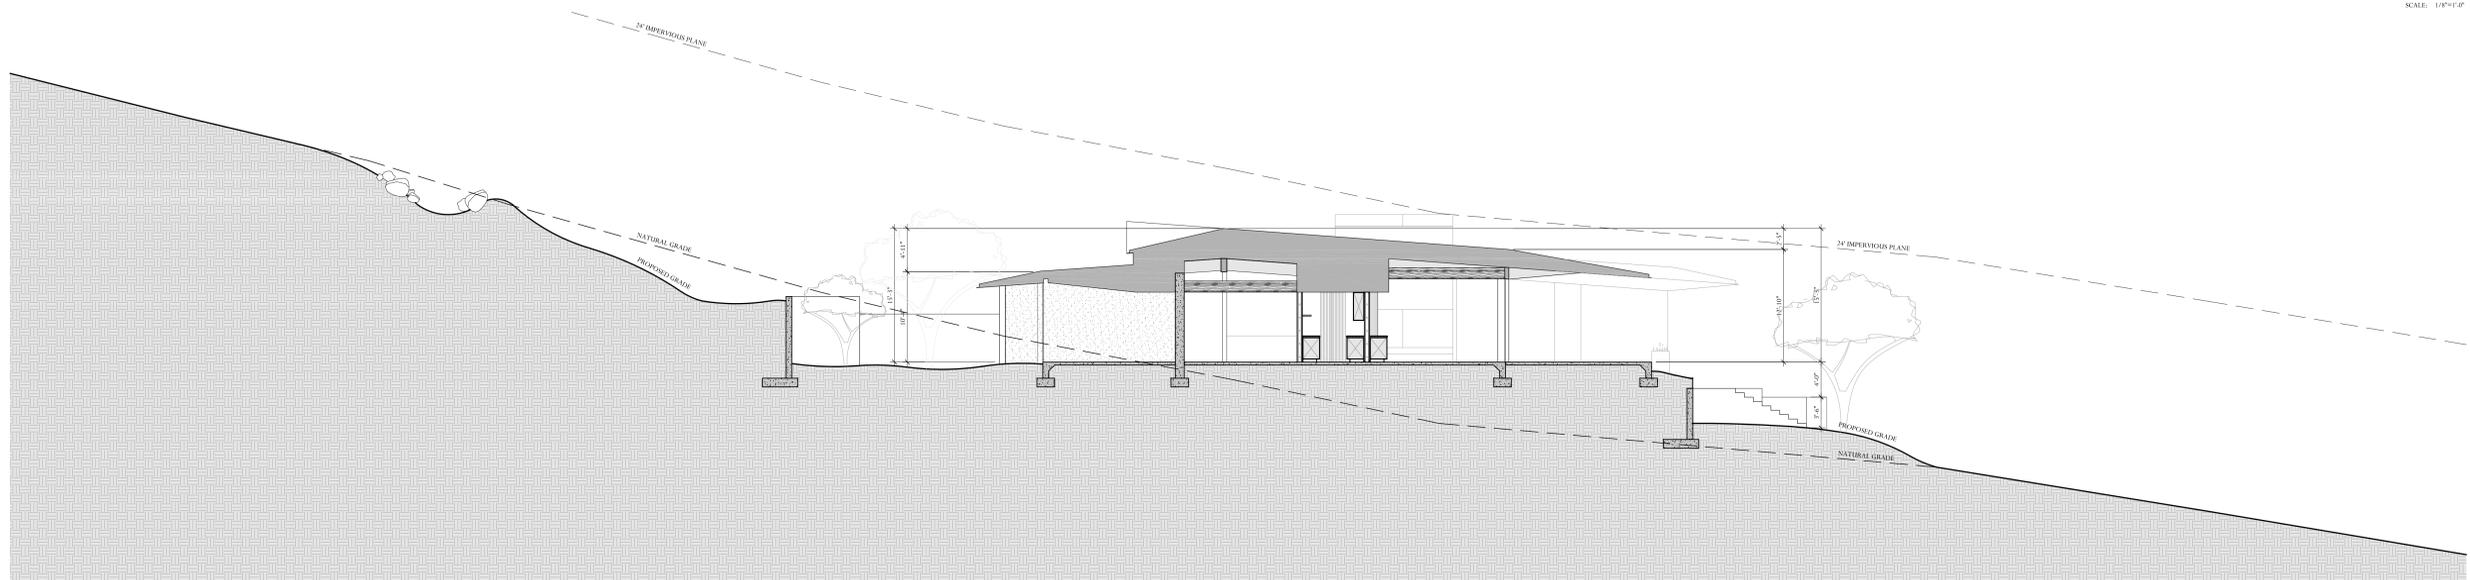

3 SITE SECTION @ BUILDING

SCALE: 1/8"=1'-0"

NO.	ISSUES/REVISIONS	DATE



PROJECT **HBL**  
 7550 N. HUMMINGBIRD LANE  
 PARADISE VALLEY, AZ 85253  
 DATE 23 OCTOBER 2018  
 SCALE 1/8"=1'-0"

BUILDING &  
 SITE SECTIONS  
 SHEET

**B A3.0**

All drawings and written material appearing herein constitute original and unpublished work of the Designer and may not be duplicated, used or disclosed without consent of Designer.